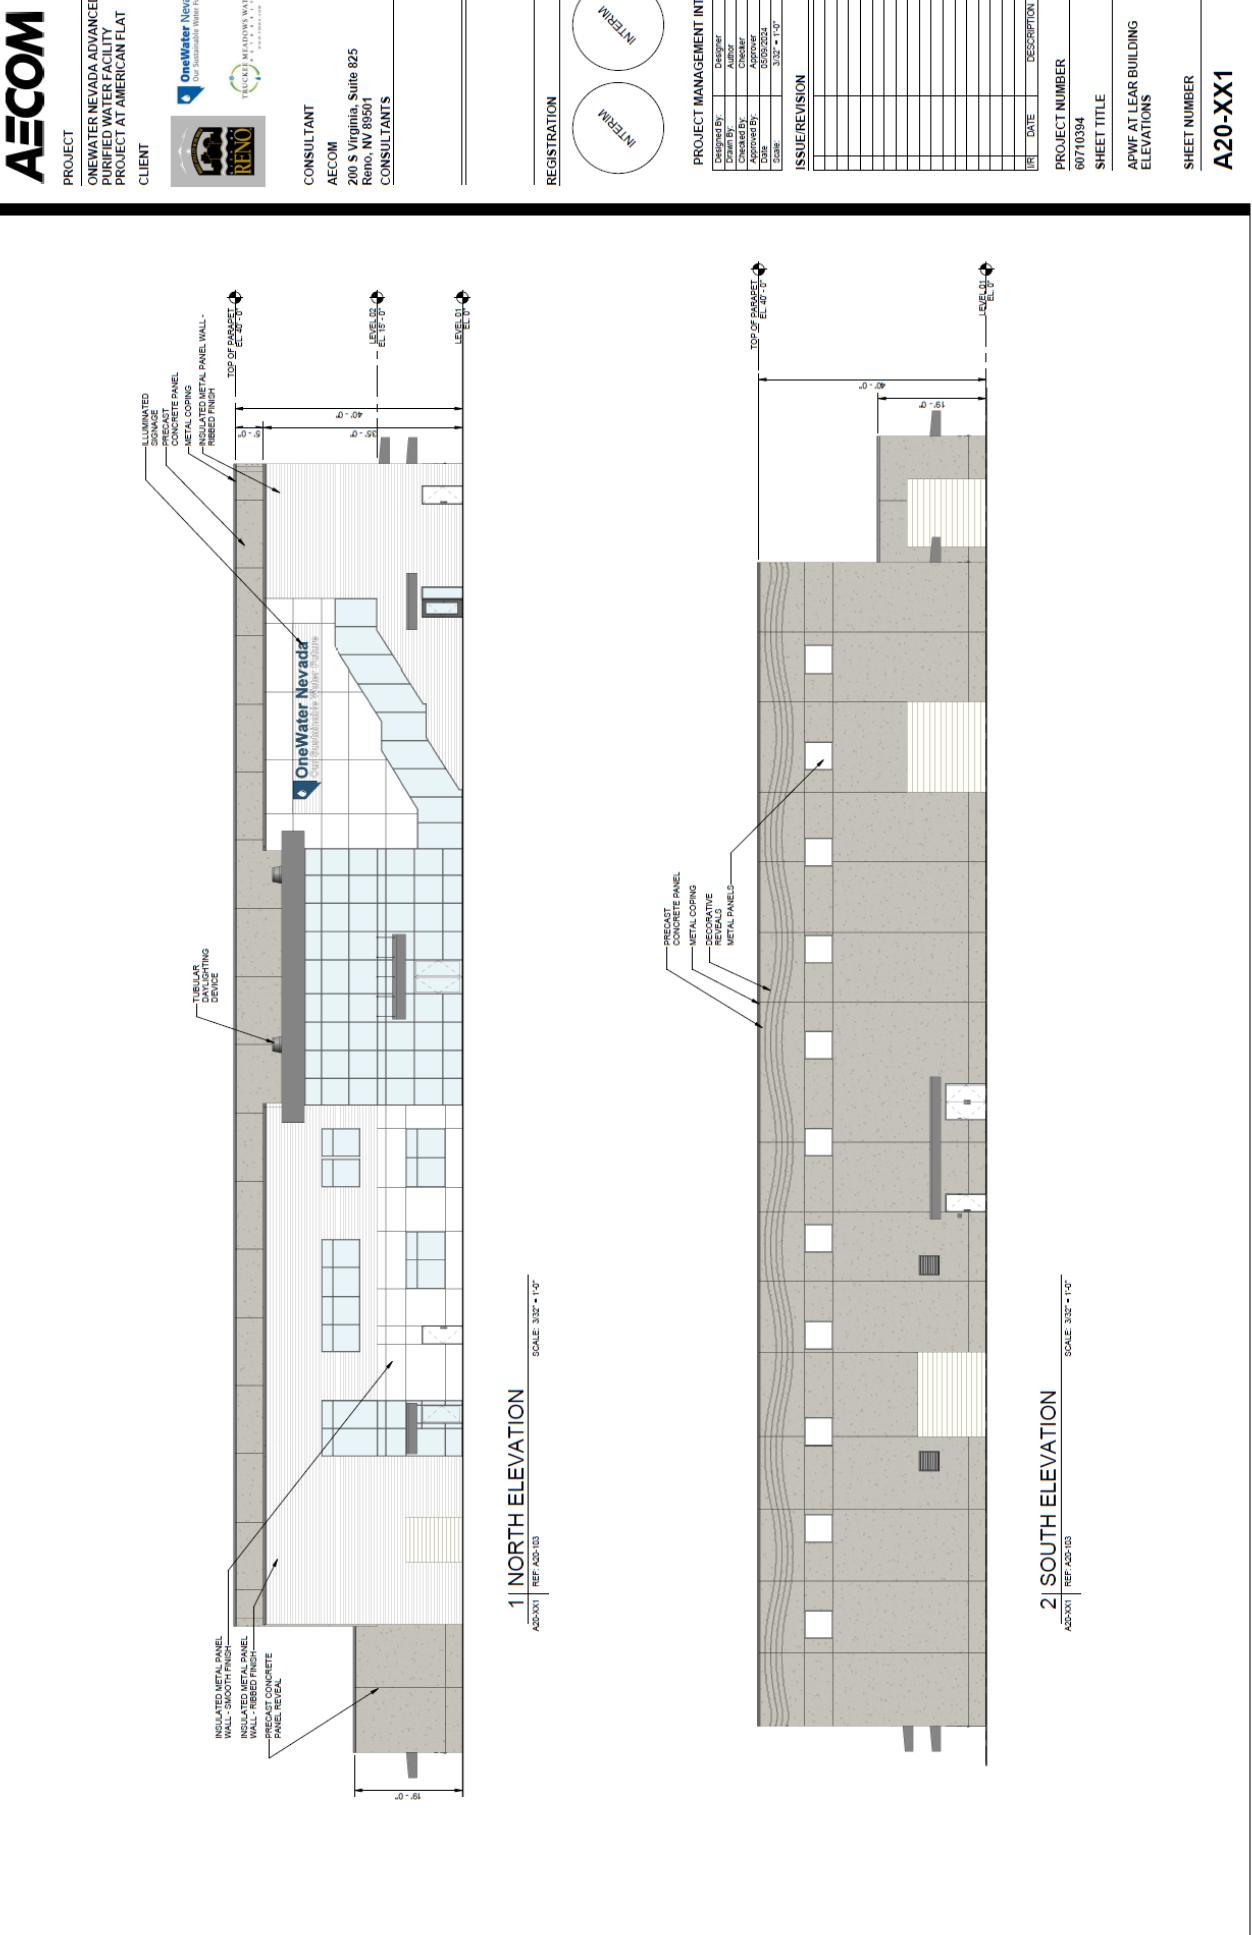


## **Exhibit E. Preliminary Elevations**



# Building Elevations

Advanced Purified Water Facility at American Flat

Conditional Use Permit Application page 42

**AECOM**

**PROJECT**  
ONEWATER NEVADA ADVANCED  
PURIFIED WATER FACILITY  
PROJECT AT AMERICAN FLAT

CLIENT



CONSULTANT



AECOM  
200 S Virginia, Suite 825  
Reno, NV 89501

CONSULTANTS

REGISTRATION



PROJECT MANAGEMENT INITIALS

INITIALS:	UN
NAME:	UN
COMPANY:	UN
PHONE:	UN
FAX:	UN
E-MAIL:	UN

ISSUE/REVISION

1	DATE ISSUED
2	DATE OF EXPIRATION
3	DATE OF LAST REVISION
4	DATE OF THIS REVISION
5	DATE OF NEXT REVIEW

PROJECT NUMBER

60710394	DATE ISSUED
60710394	DATE OF EXPIRATION
60710394	DATE OF LAST REVISION

SHEET TITLE

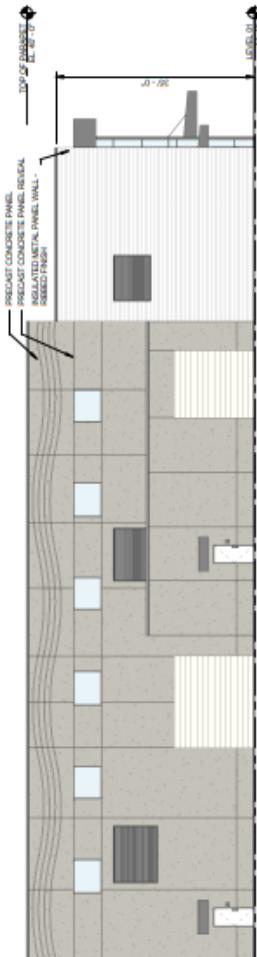
APWF AT LEAR BUILDING

ELEVATIONS

SHEET NUMBER

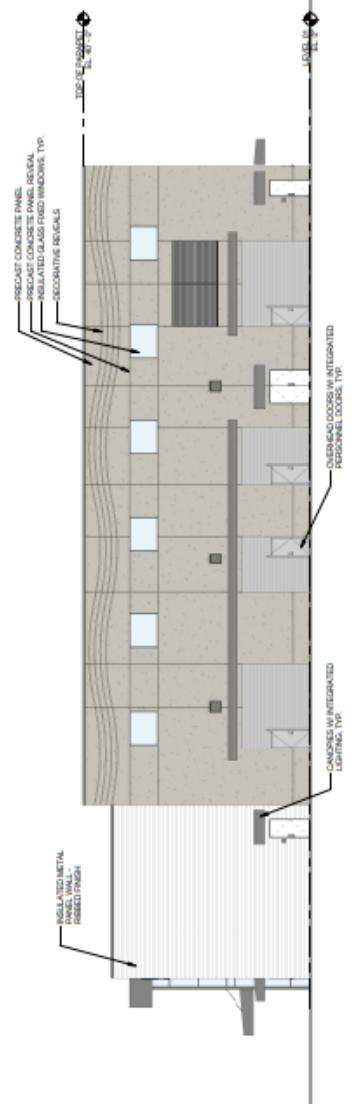
**A20-XX2**

©2018 AECOM Corporation

**1 EAST ELEVATION**

SCALE: 30'0" x 1'0"

AECOM | KEP / ADP-03

**2 WEST ELEVATION**

SCALE: 30'0" x 1'0"

AECOM | KEP / ADP-03